
NOTE:
UNDERGROUND AND OVERHEAD UTILITY LINES, SERVICES,
METERS, VALVES, IRRIGATION LINES AND VALVES, ETC
ARE PRESENT THROUGHOUT THE SITE. IT IS THE
CONTRACTORS RESPONSIBILITY TO VERIFY WITH THE
OWNER LOCATION AND REROUTING OF SAID LINES,
SERVICES, ETC.


Note:
With regard to underground utilities, information from City of Lubbock GIS and observed evidence has been utilized to developed a view of underground utilities. However, lacking excavation, the exact location of underground utilities and features cannot be accurately, completely or reliably depicted. In some areas, municipalities, 811 and other locate services will ignore locate requests from surveyors. Where additional or more detailed information is required, the client is advised that excavation and/or private utility locate request may be needed.

			TREE
AS	ASPHALT	T	FIRE HYDRANT
В	BACK OF CURB	\checkmark	FIRE HIDRANI
BC	BUILDING CORNER		(JTW JTW - DOL 5
C&G	CURB AND GUTTER	رل	UTILITY POLE
CL	CENTER LINE		
C/0	CLEAN OUT	\bigcirc	MANHOLE
C	CONCRETE		
CP	CONTROL POINT	\otimes	WATER VALVE
E	EDGE		
EX	EXISTING	(WATER METER
FC	FENCE CORNER	•	
FF FH	FINISHED FLOOR FIRE HYDRANT		SIGN
rn FL	FLOW LINE	GV	
G	GUTTER	×	GAS VALVE
G GB	GRADE BREAK	V 1	
IRR	IRRIGATION	-0	GUY WIRE
LD	LANDING		
LP	LIGHT POLE	* <u>}</u> *	LIGHT POLE
MH	MANHOLE	小个\ IRR	
N.	NATURAL GROUND	IRR	IRRIGATION
S	SANITARY SEWER LINE	\circ	
ST	STEP	G	GAS METER
SW	SIDEWALK		onto meren
TC	TOP OF CURB	\overline{E}	ELECTRIC PEDISTAL
TYP	TYPICAL	<u></u>	ELECTRIC T EDICTRIE
VG	VALLEY GUTTER	T	TELECOM PEDISTAL
W	WATER LINE	1	TELECOM FEDISTAL
WM	WATER METER	\bigcirc	SEWER CLEAN OUT
WV	WATER VALVE	c/o	SEWER CLEAN OUT
		Ź	DAD MOUNTED TRANSFORMED
		\triangle	PAD MOUNTED TRANSFORMER

Note: Elevations based on the City of Lubbock published 2021 contour data.

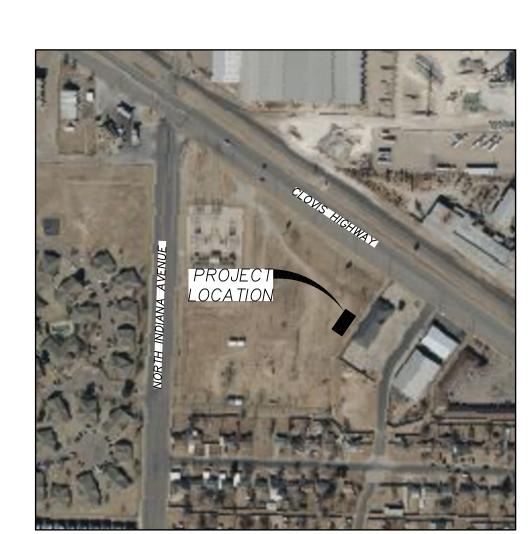

VICINITY MAP

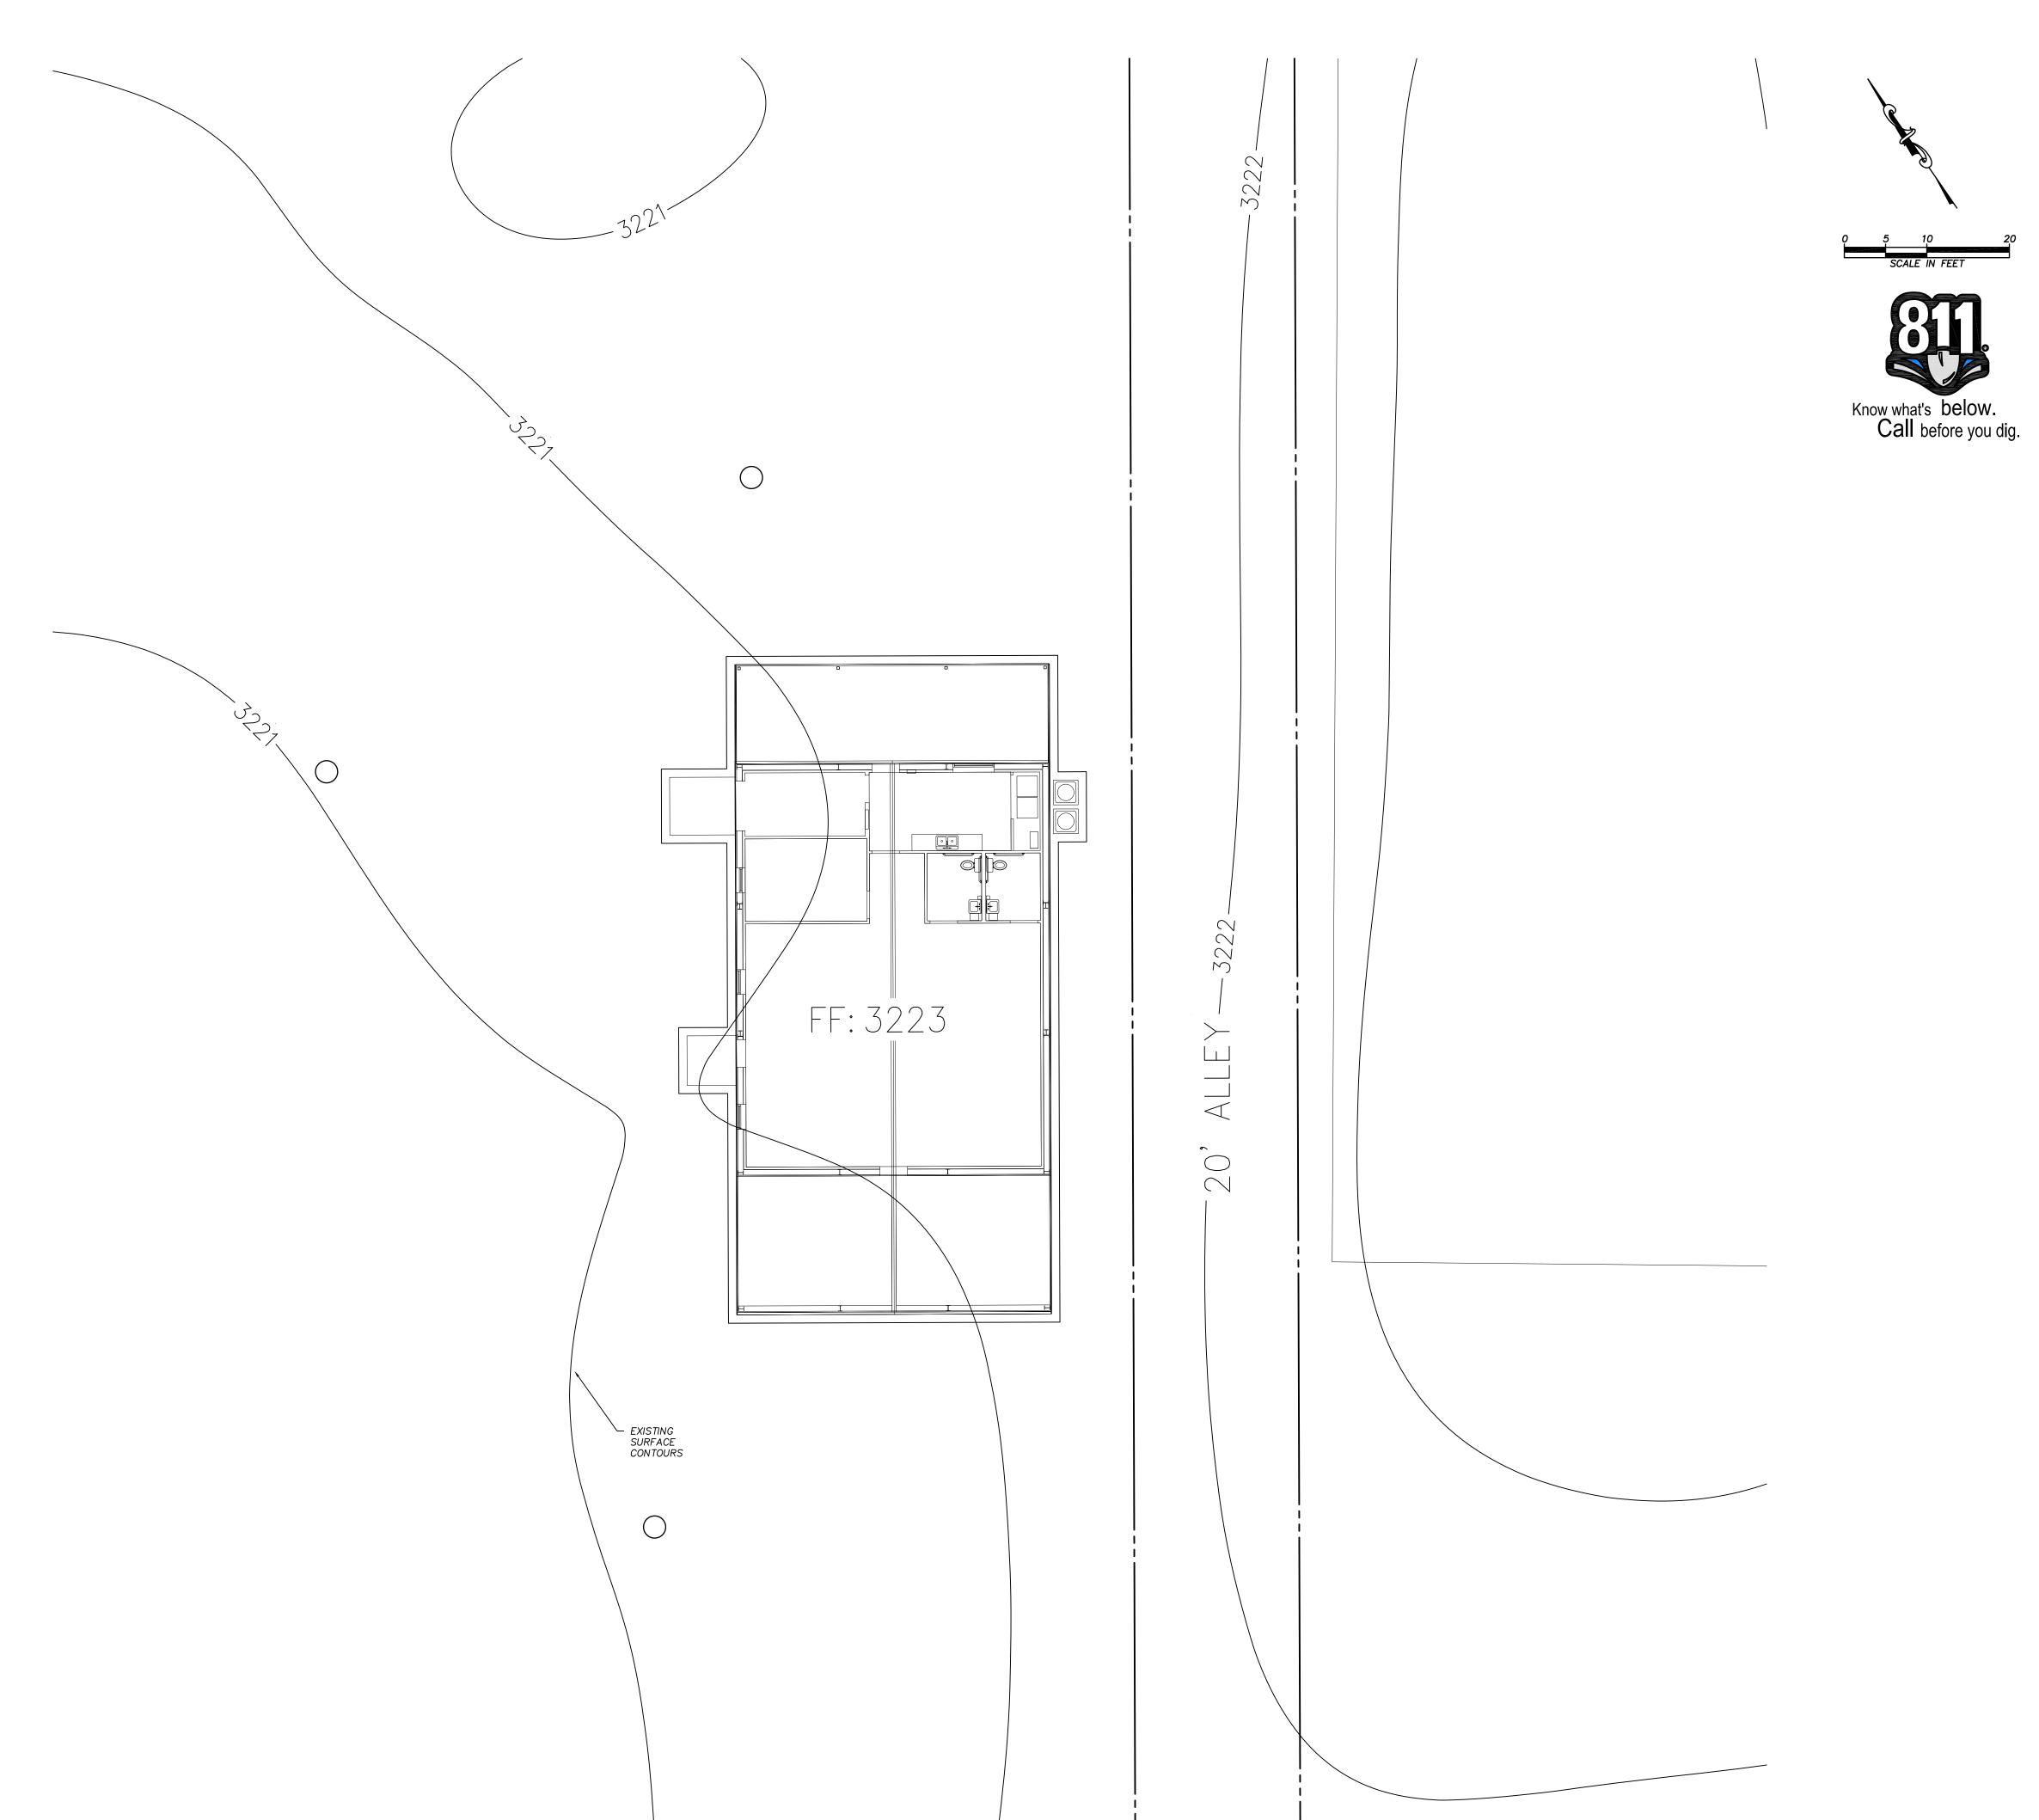

DESIGN GROU

ARCHITECTURE & INTERIOR DESIGN

3708 UPLAND AVE. LUBBOCK, TX 79407

806.748.6190 condray.com

MICHAEL J. ADAMS

FINCHER ENGINEERING, LLC

FINCHER ENGINEERING, LLC
TX FIRM #F-16408
5621 114TH ST., SUITE 100
LUBBOCK, TX 79424
PH: 806-701-5109
WWW.FINCHERENG.COM

Nieman Engineering, LLC 1500 Broadway St, Suite 1210 Lubbock, Texas 79401 T: 806-589-3340 TBPE Firm Registration No: F- 14148

OJD Engineering, LLC TX FIRM #F-4393

328 E. Hwy 62, Unit 1 WOLFFORTH, TX 79382 PH: 806-791-2300

COPYRIGHT © 2024 CONDRAY DESIGN GROUP, INC. THESE DRAWINGS, OR, PARTS THEREOF, MAY NOT BE REPRODUCED IN ANY FORM, BY ANY METHOD, FOR ANY PURPOSE, WITHOUT PRIOR WRITTEN CONSENT FROM CONDRAY DESIGN GROUP, INC.

SHEET NO.

2 OF 2

SITE GRADING PLAN